


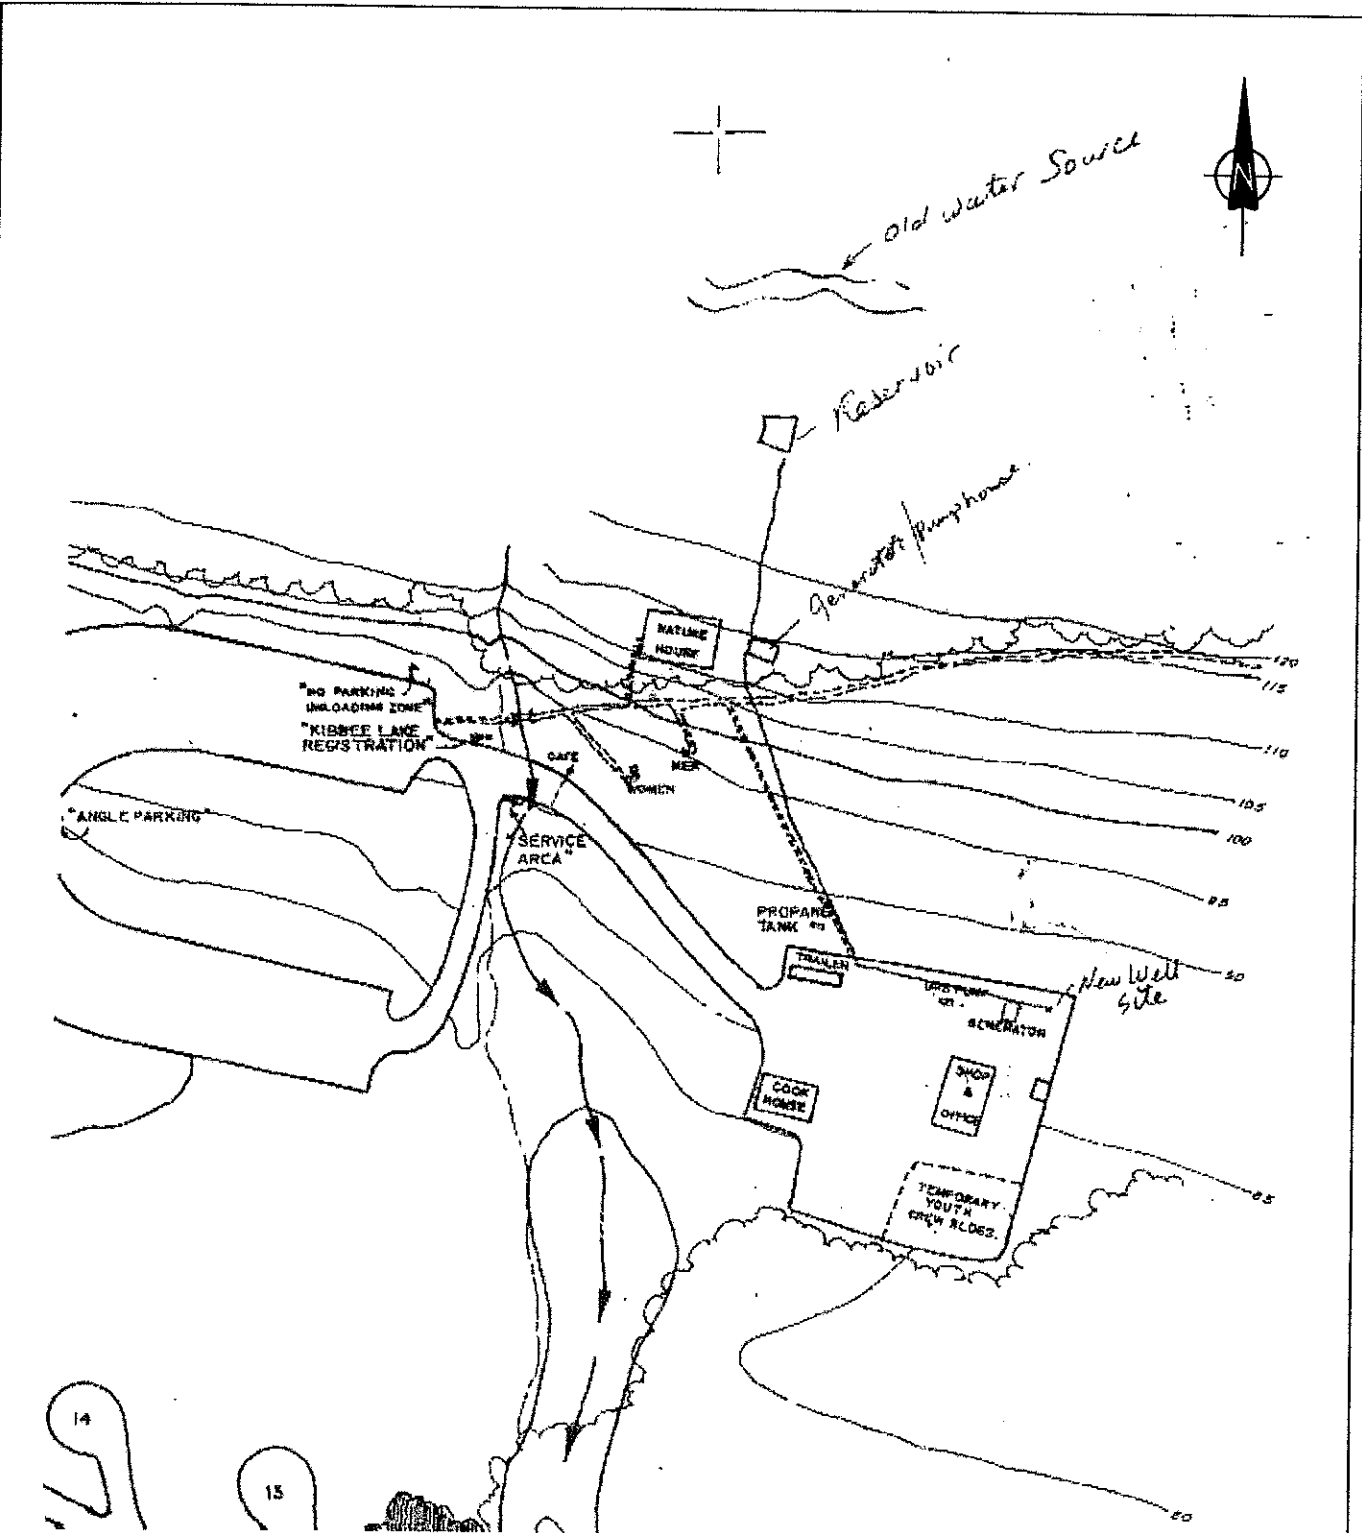

This site sketch was provided to Jacques Whitford by ND LEA Consultants Ltd. for reference only.

This drawing is part of a Jacques Whitford Limited report and its use is subject to the limitations expressed in the Statement of Limitations section of that report.

THIS DRAWING IS NOT TO SCALE

	CLIENT: MINISTRY OF WATER, LAND AND AIR PROTECTION		SITE PLAN SKETCH WATER WELL & STANDPIPE SAMPLING PROGRAM BOWRON LAKE PROVINCIAL PARK, BRITISH COLUMBIA	DWG No: 2
	PROJECT No:	BCV61838	DATE: 18-Aug-04	
	DRAWN BY:	MW	CHECKED BY:	

THIS DRAWING WAS ORIGINALLY PRODUCED IN COLOUR

FILENAME: Bcv61838 D02 R0

Appendix B
Appendix C
Appendix D