




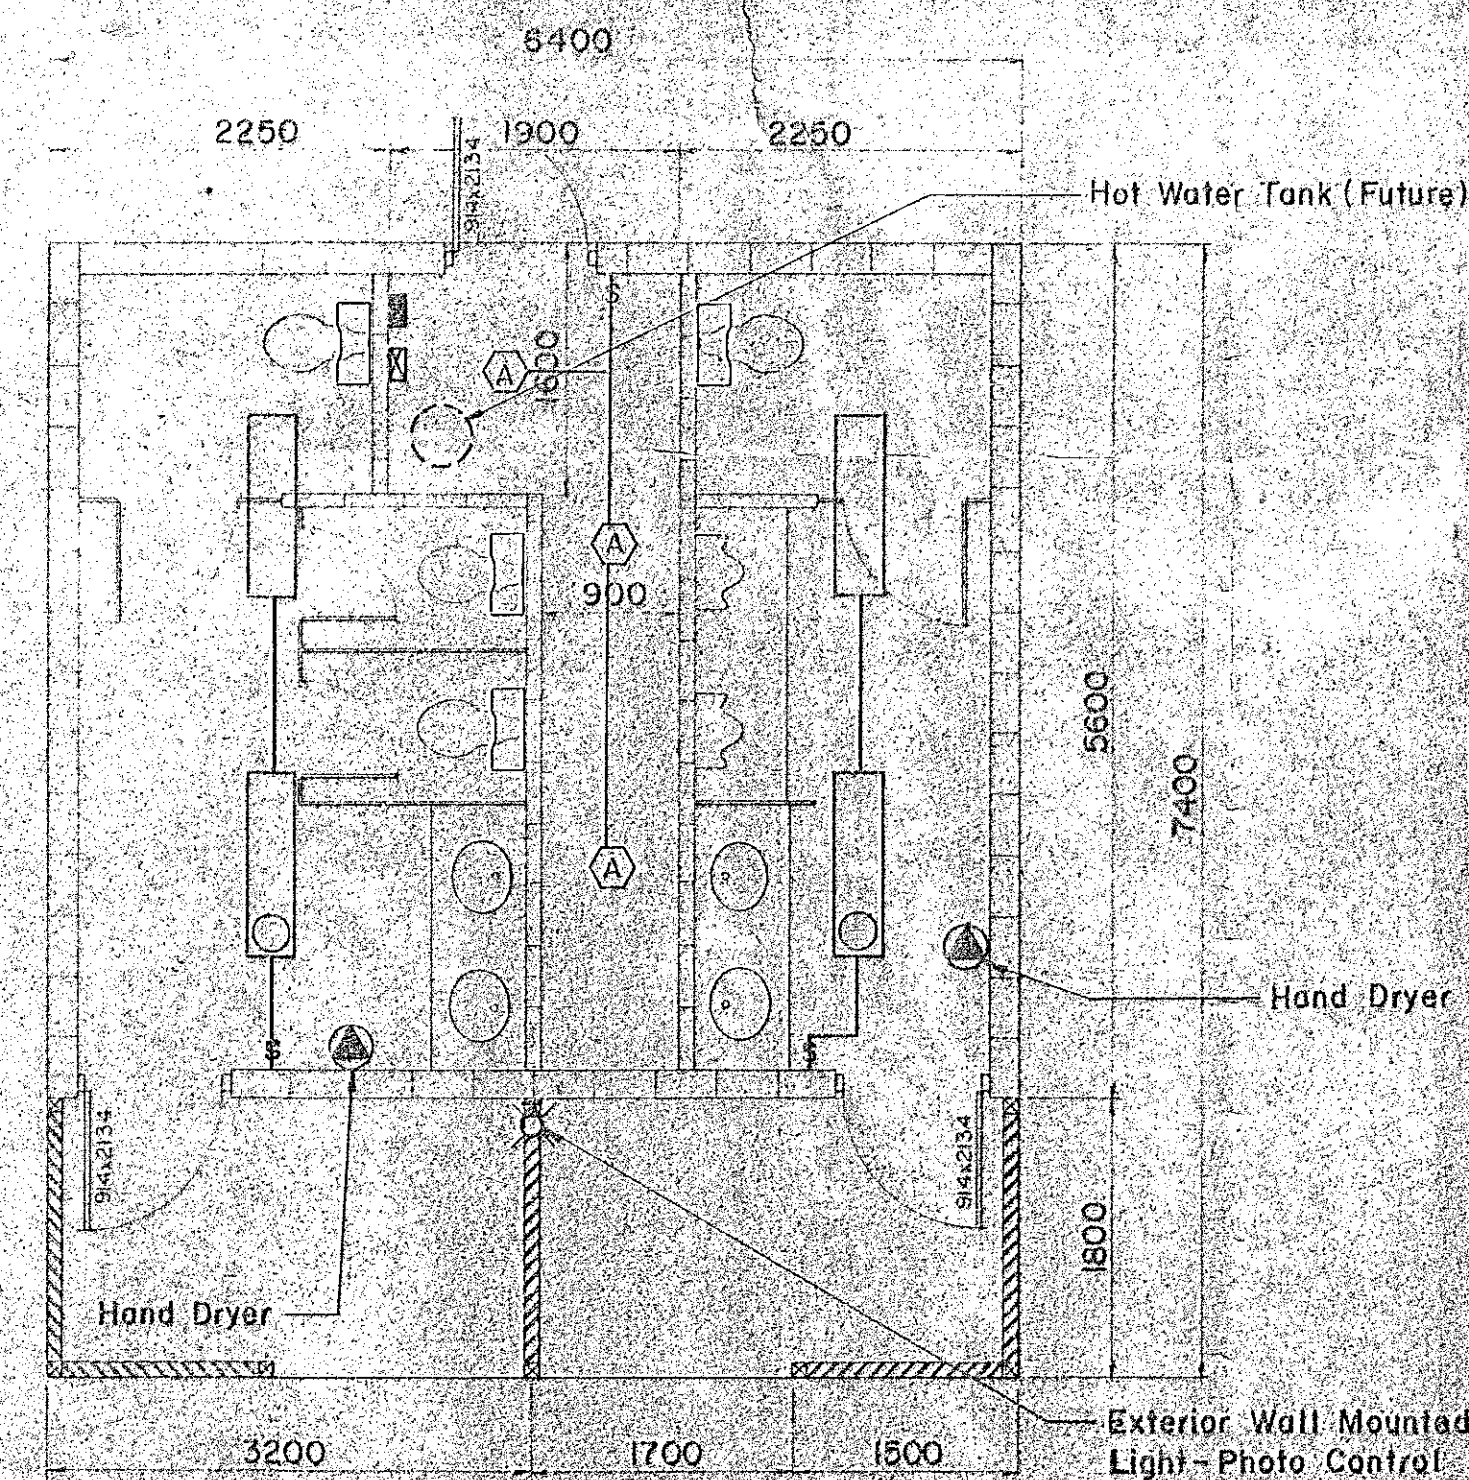


0 1000 2000
SCALE IN mm

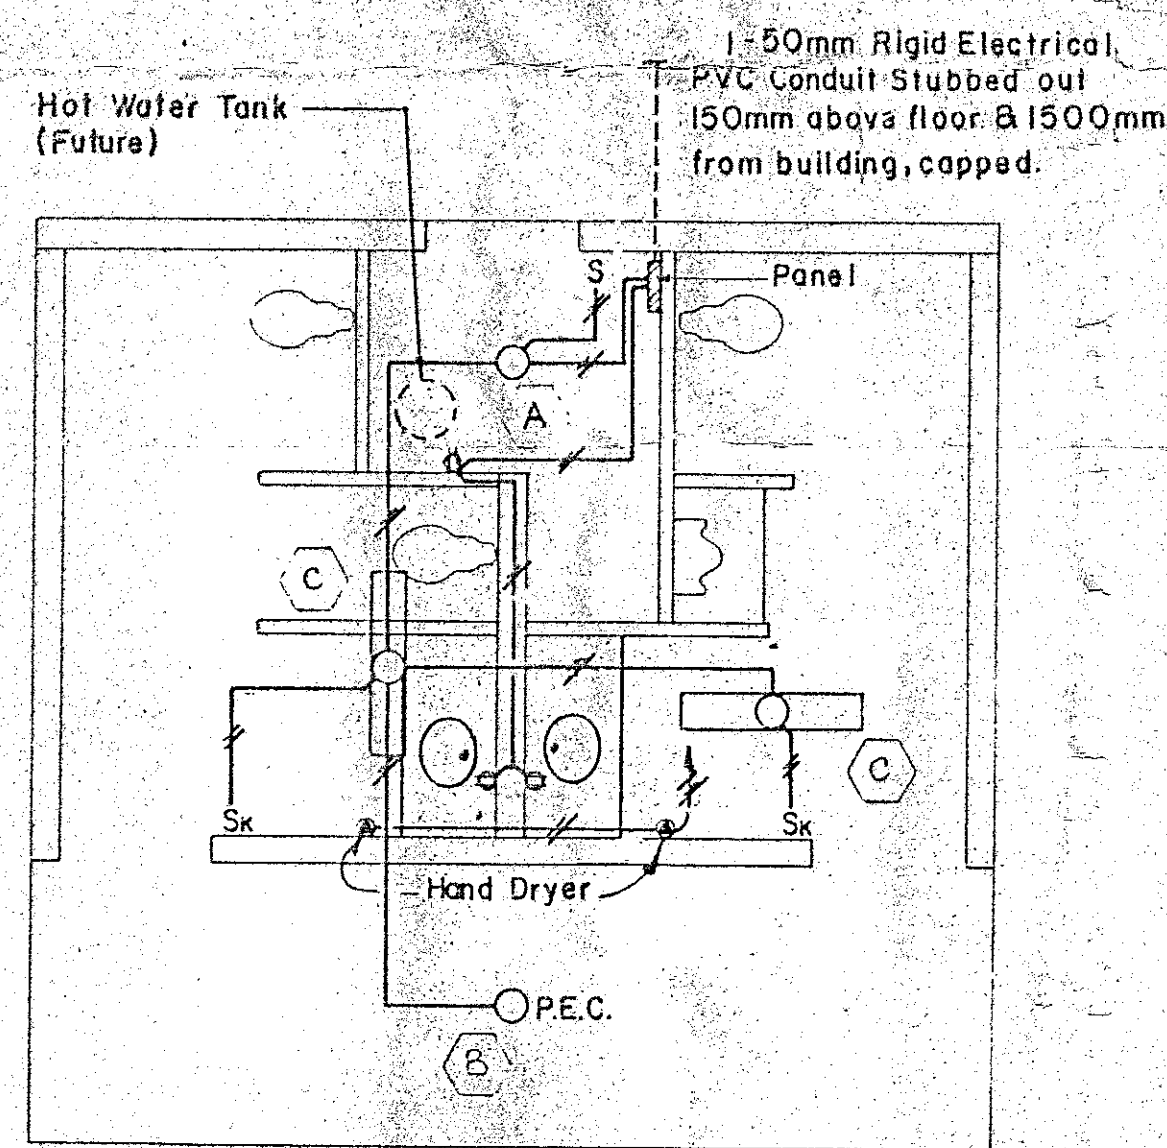


PLAN - BUILDING C

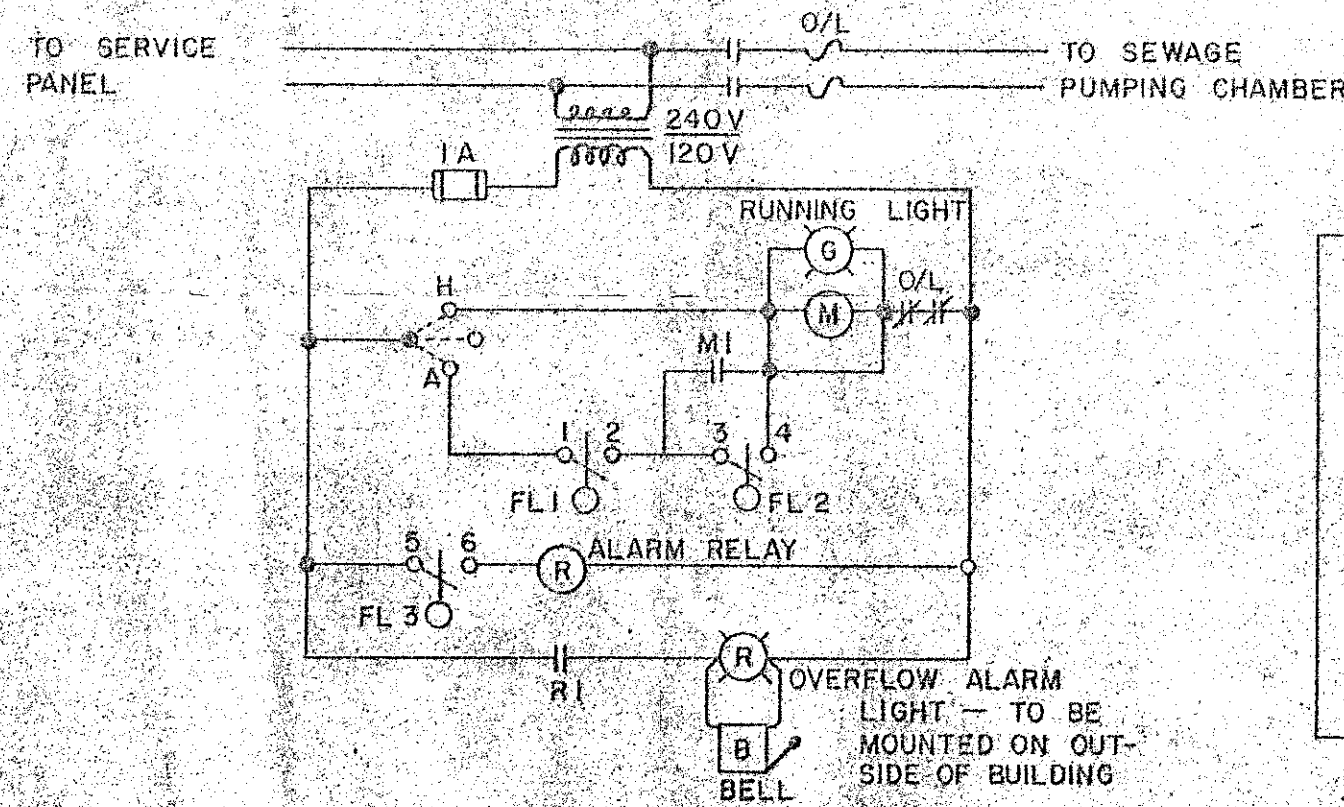

TYPICAL SEWAGE PUMP CONTROL DIAGRAM

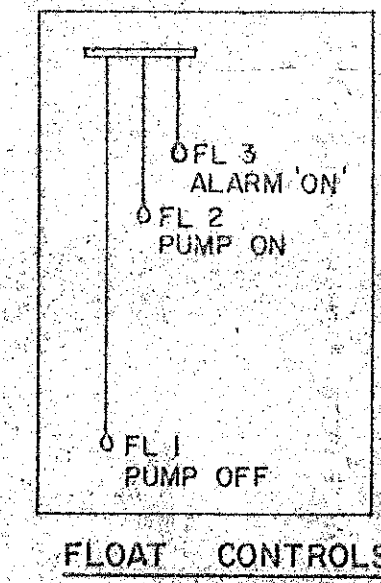


FLOOD CONTROLS

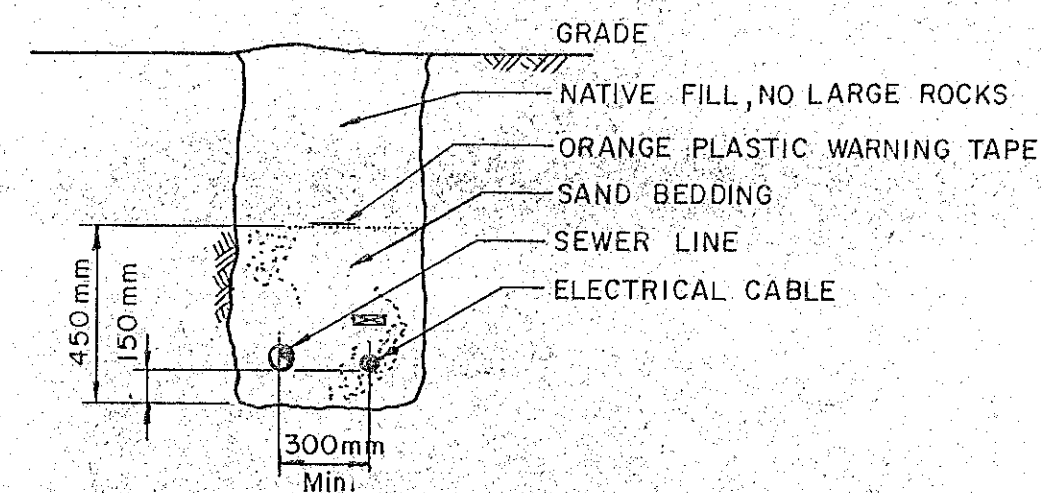


TYPICAL TRENCH DETAIL

NOTE: TREATED PLANK PROTECTION OF CABLE IS REQUIRED EXCEPT WHERE CABLE IS BURIED MORE THAN 1m. IN NON TRAFFIC AREAS.
PLANK TO BE 150mm ABOVE CABLE.

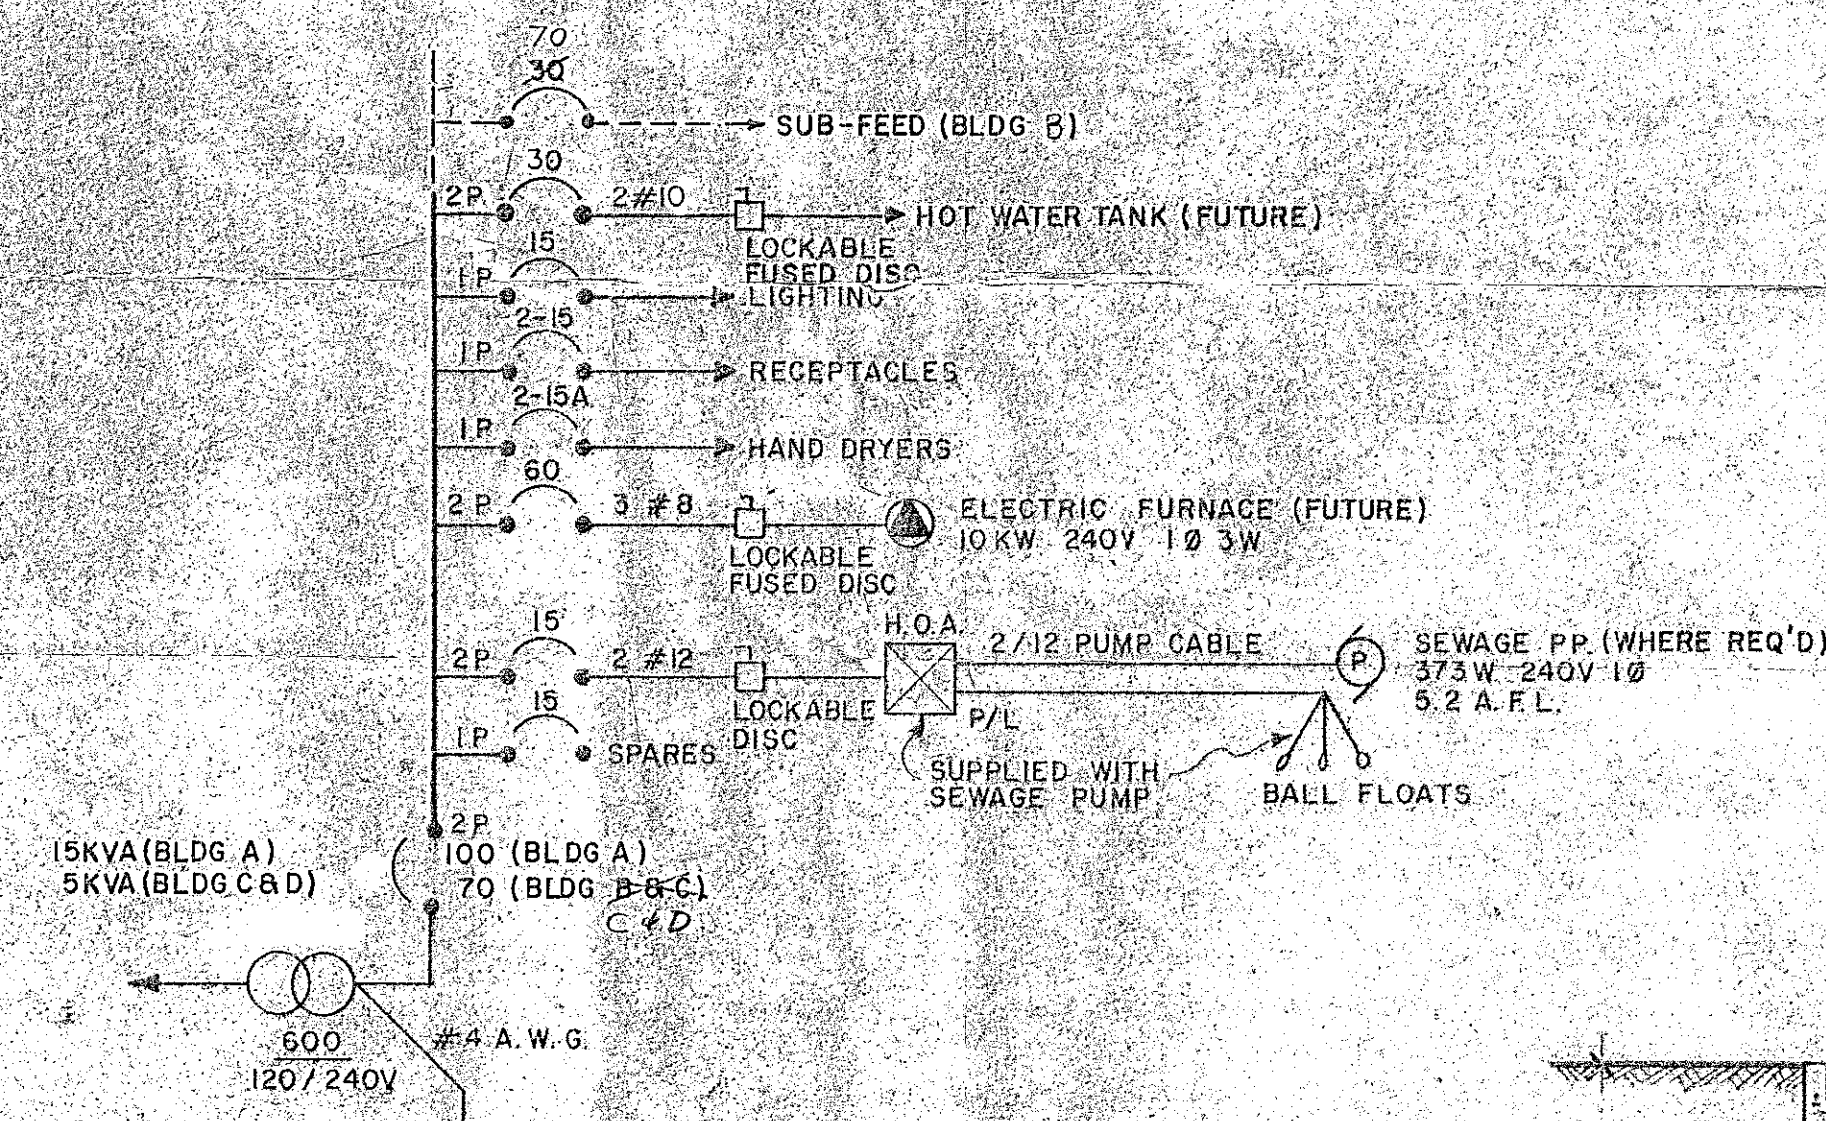

MAIN SERVICE PANEL - BUILDING A, B, C & D

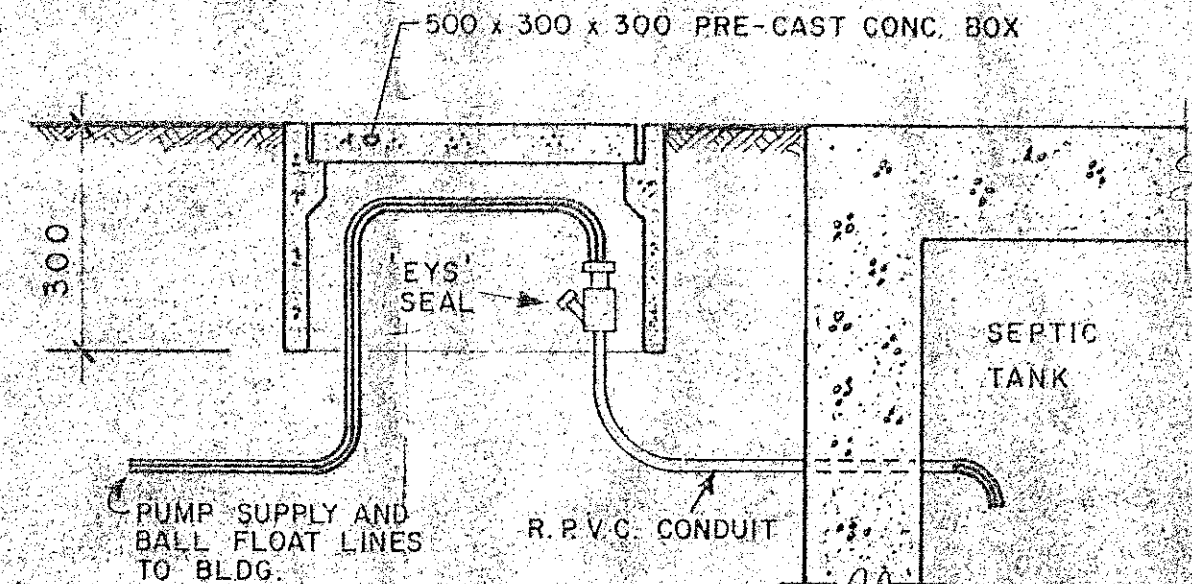


DETAIL OF WIRING LEAVING SEPTIC TANK

LUMINAIRE SCHEDULE

- (A) 4" KEYLESS PORCELAIN 100W
- (B) KENALL LIGHTMATE # 3663
- (C) SYLVANIA K210-248
- (D) RAB SRWP100 c/w PHOTO CONT.

LEGEND

- ⊕ DUPLEX RECEPTACLE
- S S.P. SWITCH
- CEILING
- ⊕ WALL MOUNTED LIGHT
- P.E.C. PHOTO CONTROL
- S.P. OUTLET
- ⊕ PANEL BOARD
- ⊕ CONTROL PANEL
- ⊕ DISCONNECT SW.
- ⊕ 2/40W FLOURESCENT FIXTURE

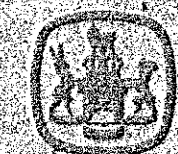

THE PROVINCE OF BRITISH COLUMBIA
MINISTRY OF LANDS, PARKS AND HOUSING
PARKS AND OUTDOOR RECREATION DIVISION

No.	Revision	Drawn	Date	Checked
1				
2				
3				
4				
5				
6				
7				
8				
9				
10				

Approved	Position	Date
	Regional Director	
	Manager, Technical Services	
	Director, Park Programs Branch	
Drawn	Checked	Design
Date	Date	Date

TEN MILE LAKE PROVINCIAL PARK			
4 UNIT & 6 UNIT TOILET BUILDINGS			
ELECTRICAL			
(BLDGs A, B, C & D)			
Project No.	Sheet	Dwg	No.
	12 of 12	1-1-5	SP 11-12