



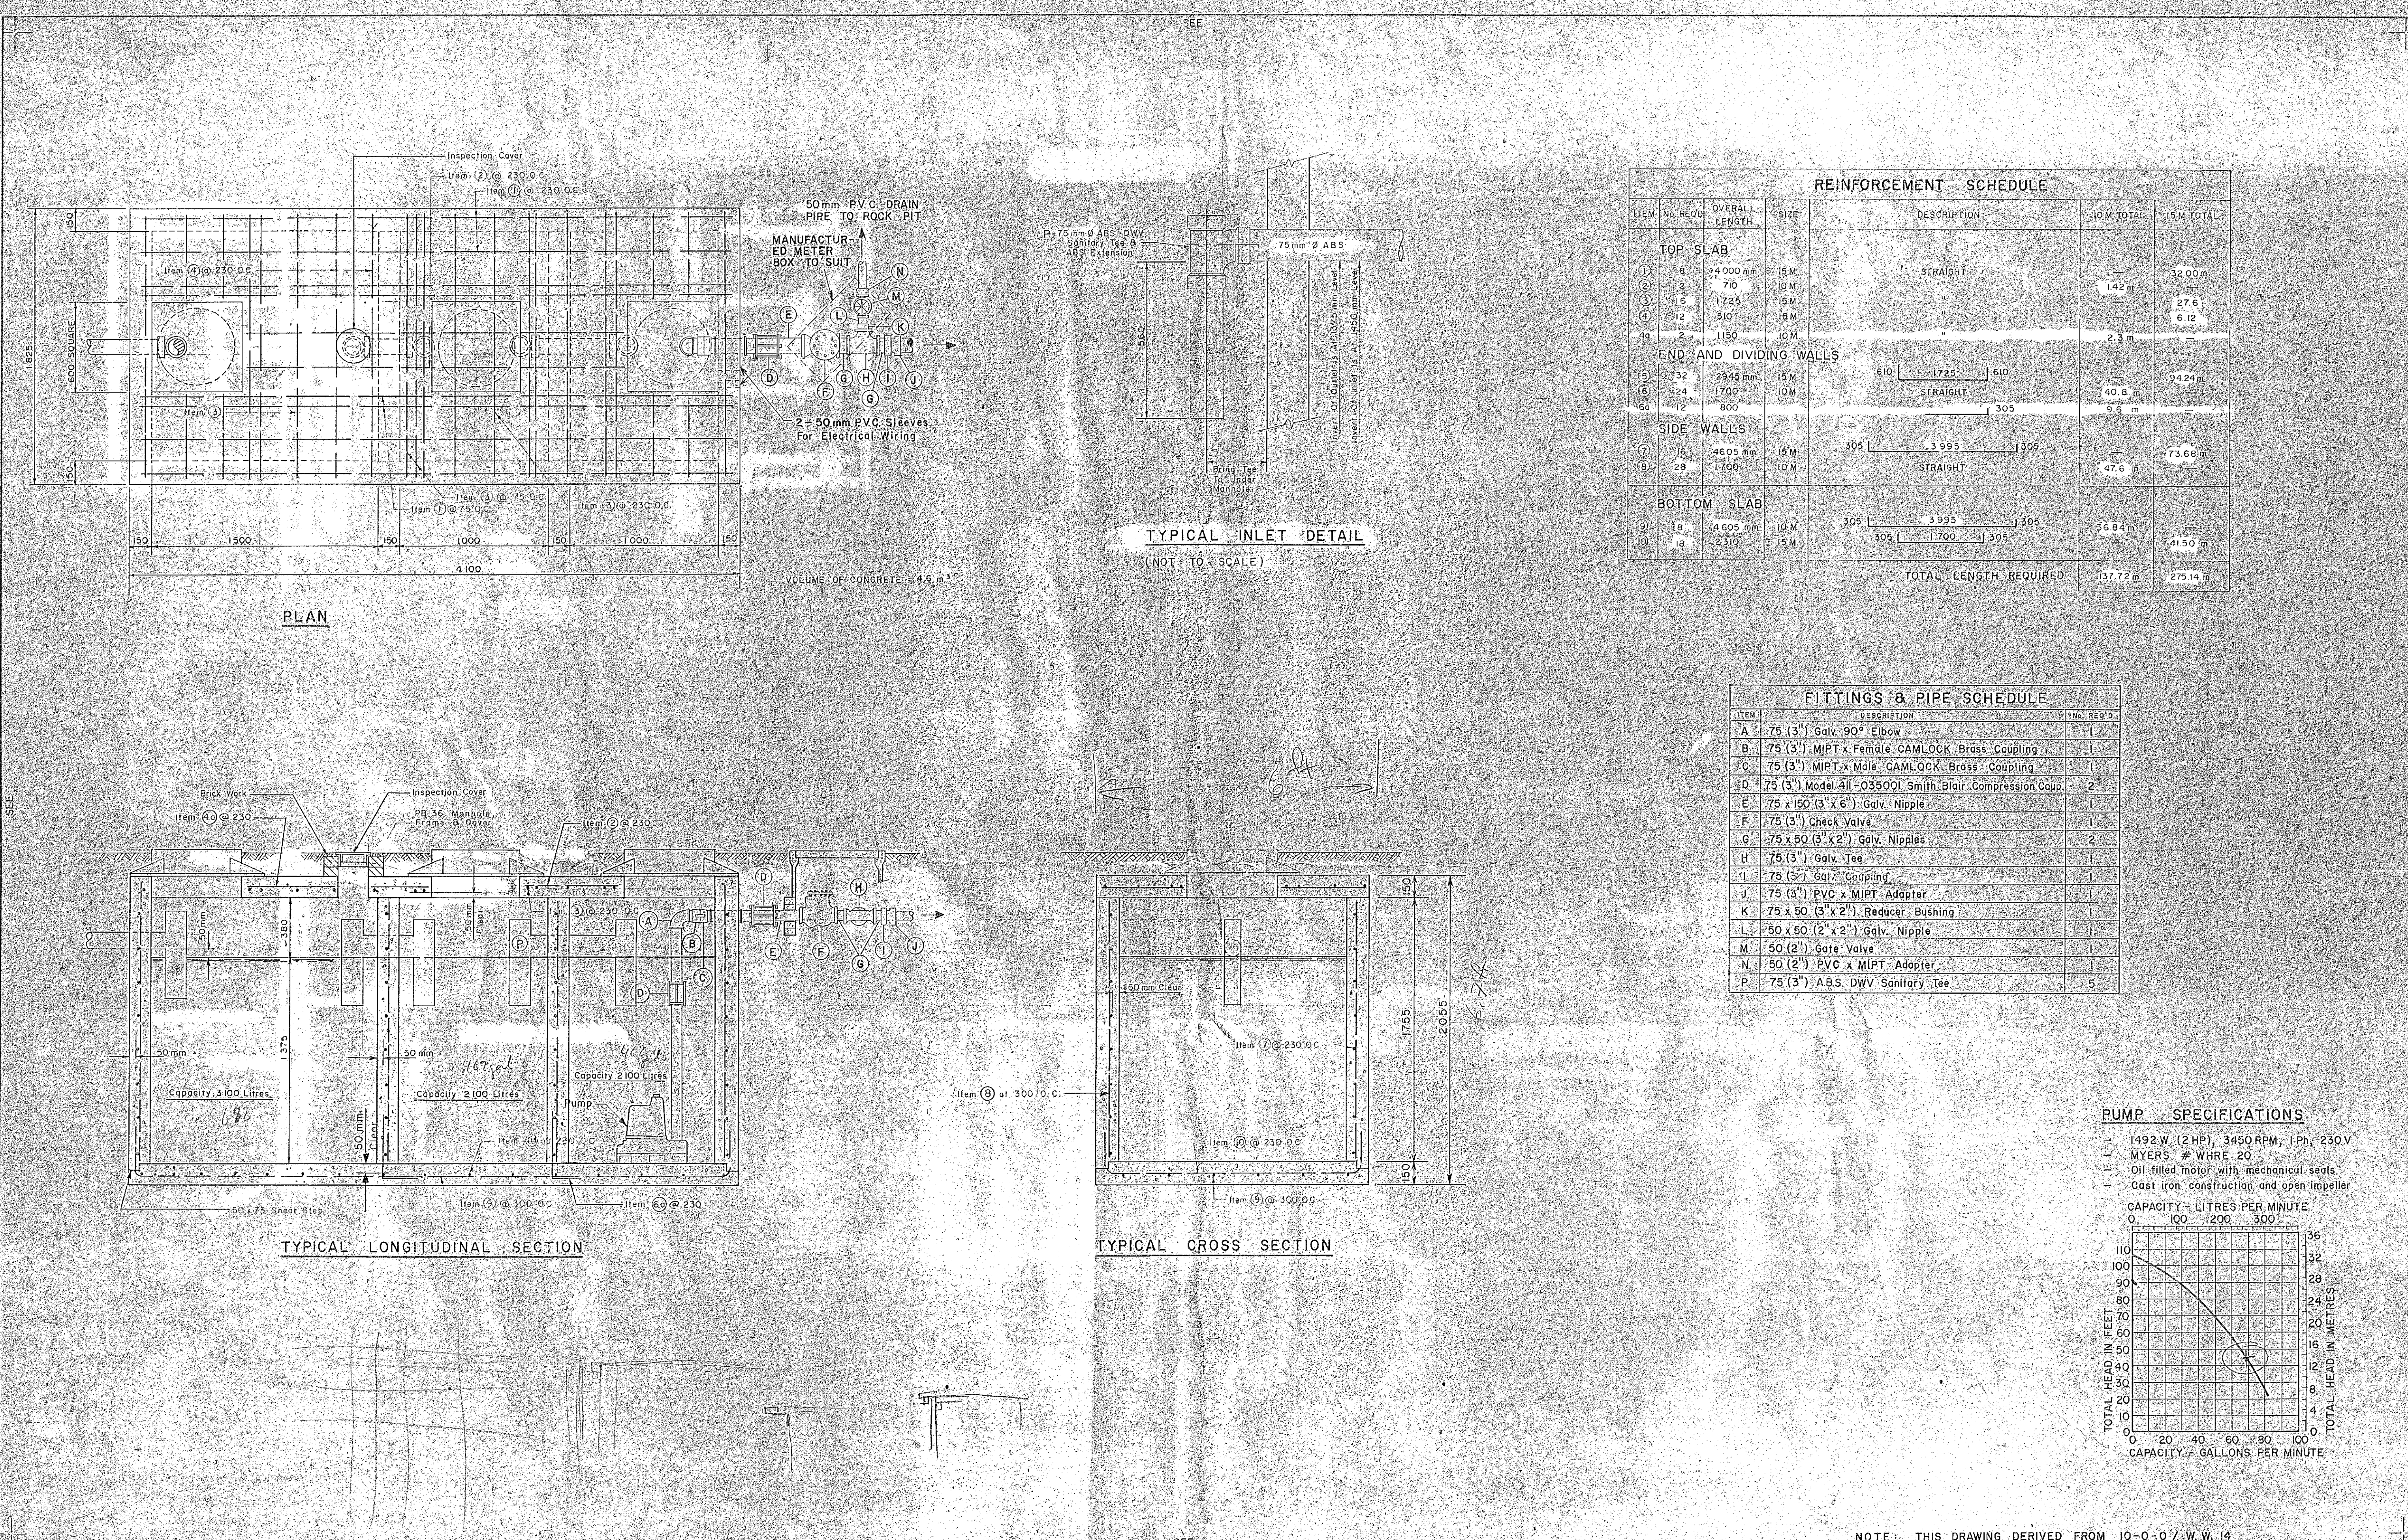

REINFORCEMENT SCHEDULE						
ITEM	No. REQ'D	OVERALL LENGTH	SIZE	DESCRIPTION	10 M. TOTAL	15 M. TOTAL
TOP SLAB						
1	8	4000 mm	15 M	STRAIGHT	142 m	32.00 m
2	2	710	10 M			27.6
3	15	1735	15 M			6.12
4	12	510	15 M			
4a	2	1150	10 M		2.3 m	
END AND DIVIDING WALLS						
5	32	2945 mm	15 M	STRAIGHT	94.24 m	
6	24	1700	10 M		40.8 m	
6a	12	800			9.6 m	
SIDE WALLS						
7	16	4605 mm	15 M	STRAIGHT	73.68 m	
8	28	1700	10 M		47.6	
BOTTOM SLAB						
9	8	4005 mm	10 M		36.84 m	
10	18	2310	15 M		41.50 m	
TOTAL LENGTH REQUIRED					137.72 m	275.14 m

FITTINGS & PIPE SCHEDULE		
ITEM	DESCRIPTION	No. REQ'D
A	75 (3") Galv. 90° Elbow	1
B	75 (3") MIPT x Female CAMLOCK Brass Coupling	1
C	75 (3") MIPT x Male CAMLOCK Brass Coupling	1
D	75 (3") Model 411-035001 Smith Blair Compression Coup.	2
E	75 x 150 (3" x 6") Galv. Nipple	1
F	75 (3") Check Valve	1
G	75 x 50 (3" x 2") Galv. Nipples	2
H	75 (3") Galv. Tee	1
I	75 (3") Galv. Coupling	1
J	75 (3") PVC x MIPT Adapter	1
K	75 x 50 (3" x 2") Reducer Bushing	1
L	50 x 50 (2" x 2") Galv. Nipple	1
M	50 (2") Gate Valve	1
N	50 (2") PVC x MIPT Adapter	1
P	75 (3") A.B.S. DWV Sanitary Tee	5

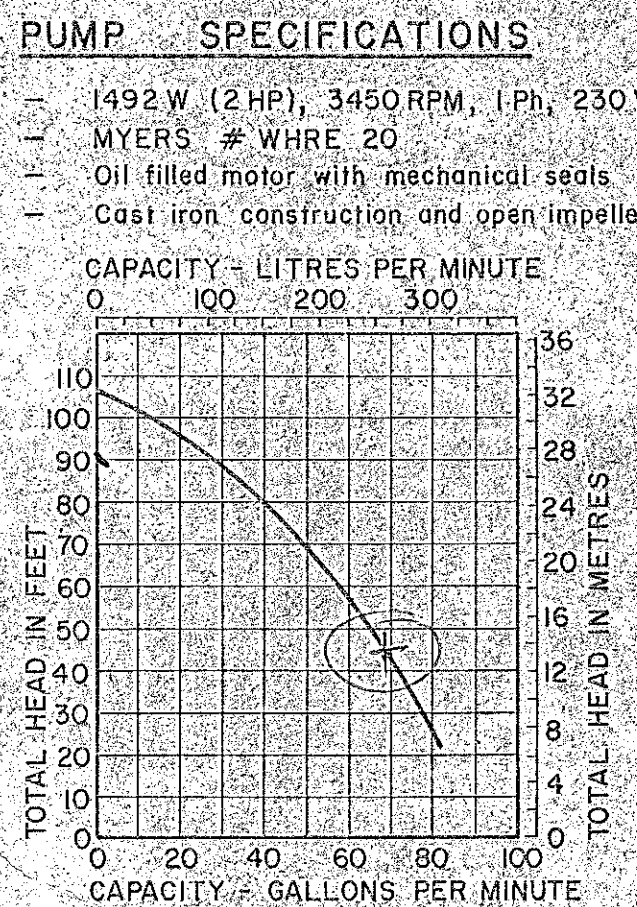

No.	REVISION	DRAWN	DATE	CHECKED	DRAWN DATE	CHECKED DATE	SURVEY DATE	DESIGN DATE

APPROVED

POSITION

DATE

NATIONAL TOPOGRAPHIC SHEET 93 G/2

FILE NUMBER 2-1-1-5

MICROFILM NUMBER 1195

5 SHEET OF 12

TEN MILE LAKE PROVINCIAL PARK

5.2kl SEPTIC TANK (BLDG C)

0 400 800 1200 1600 2000 SCALE IN mm

DWG 1-1-5 No. SP11-5

10-0-0-7

SEE

SEE

NOTE: THIS DRAWING DERIVED FROM 10-0-0-7 W.W. 14