




Item	Part No.	Description	Quantity
1	2130	Ø75 x Ø75 x Ø50 Sanitary Tee Reducing	1
2	2152	Ø50 x Ø50 x Ø50 Sanitary Tee	2
3	2188	Ø50 x Ø50 x Ø40 x Ø40 Double Sanitary Tee Reducing	3
4	2276	Ø40 90° Extra Long Elbow	4
5	2277	Ø50 90° Extra Long Elbow	4
6	2278	Ø75 90° Extra Long Elbow	4
7	2304	Ø100 45° Wye	2
8	2327	Ø100 x Ø100 x Ø75 45° Wye Reducing	4
9	2381	Ø100 x Ø100 x Ø75 x Ø75 Double 45° Wye Reducing	4
10	2503	Ø75 45° Elbow	1
11	2504	Ø100 45° Elbow	1
12	2552	Ø50 22 1/2° Elbow	3
13	2553	Ø75 22 1/2° Elbow	2
14	2756	Ø100 x Ø75 Bushing	2
15	2860A3	Ø50 x Ø40 Pipe Trap Adapter - Brass Nut	4
16	3054	Ø100 Plug	1
17	3202	Ø50 P Trap	2
18	3203	Ø75 P Trap	3
19	3624	Ø100 x Ø75 Adjustable Closet Flange	4
20	3704	Ø100 Fitting Cleanout Adapter	1
21	4327	Ø100 x Ø100 x Ø50 Long Turn Tee Wye Reducing	5

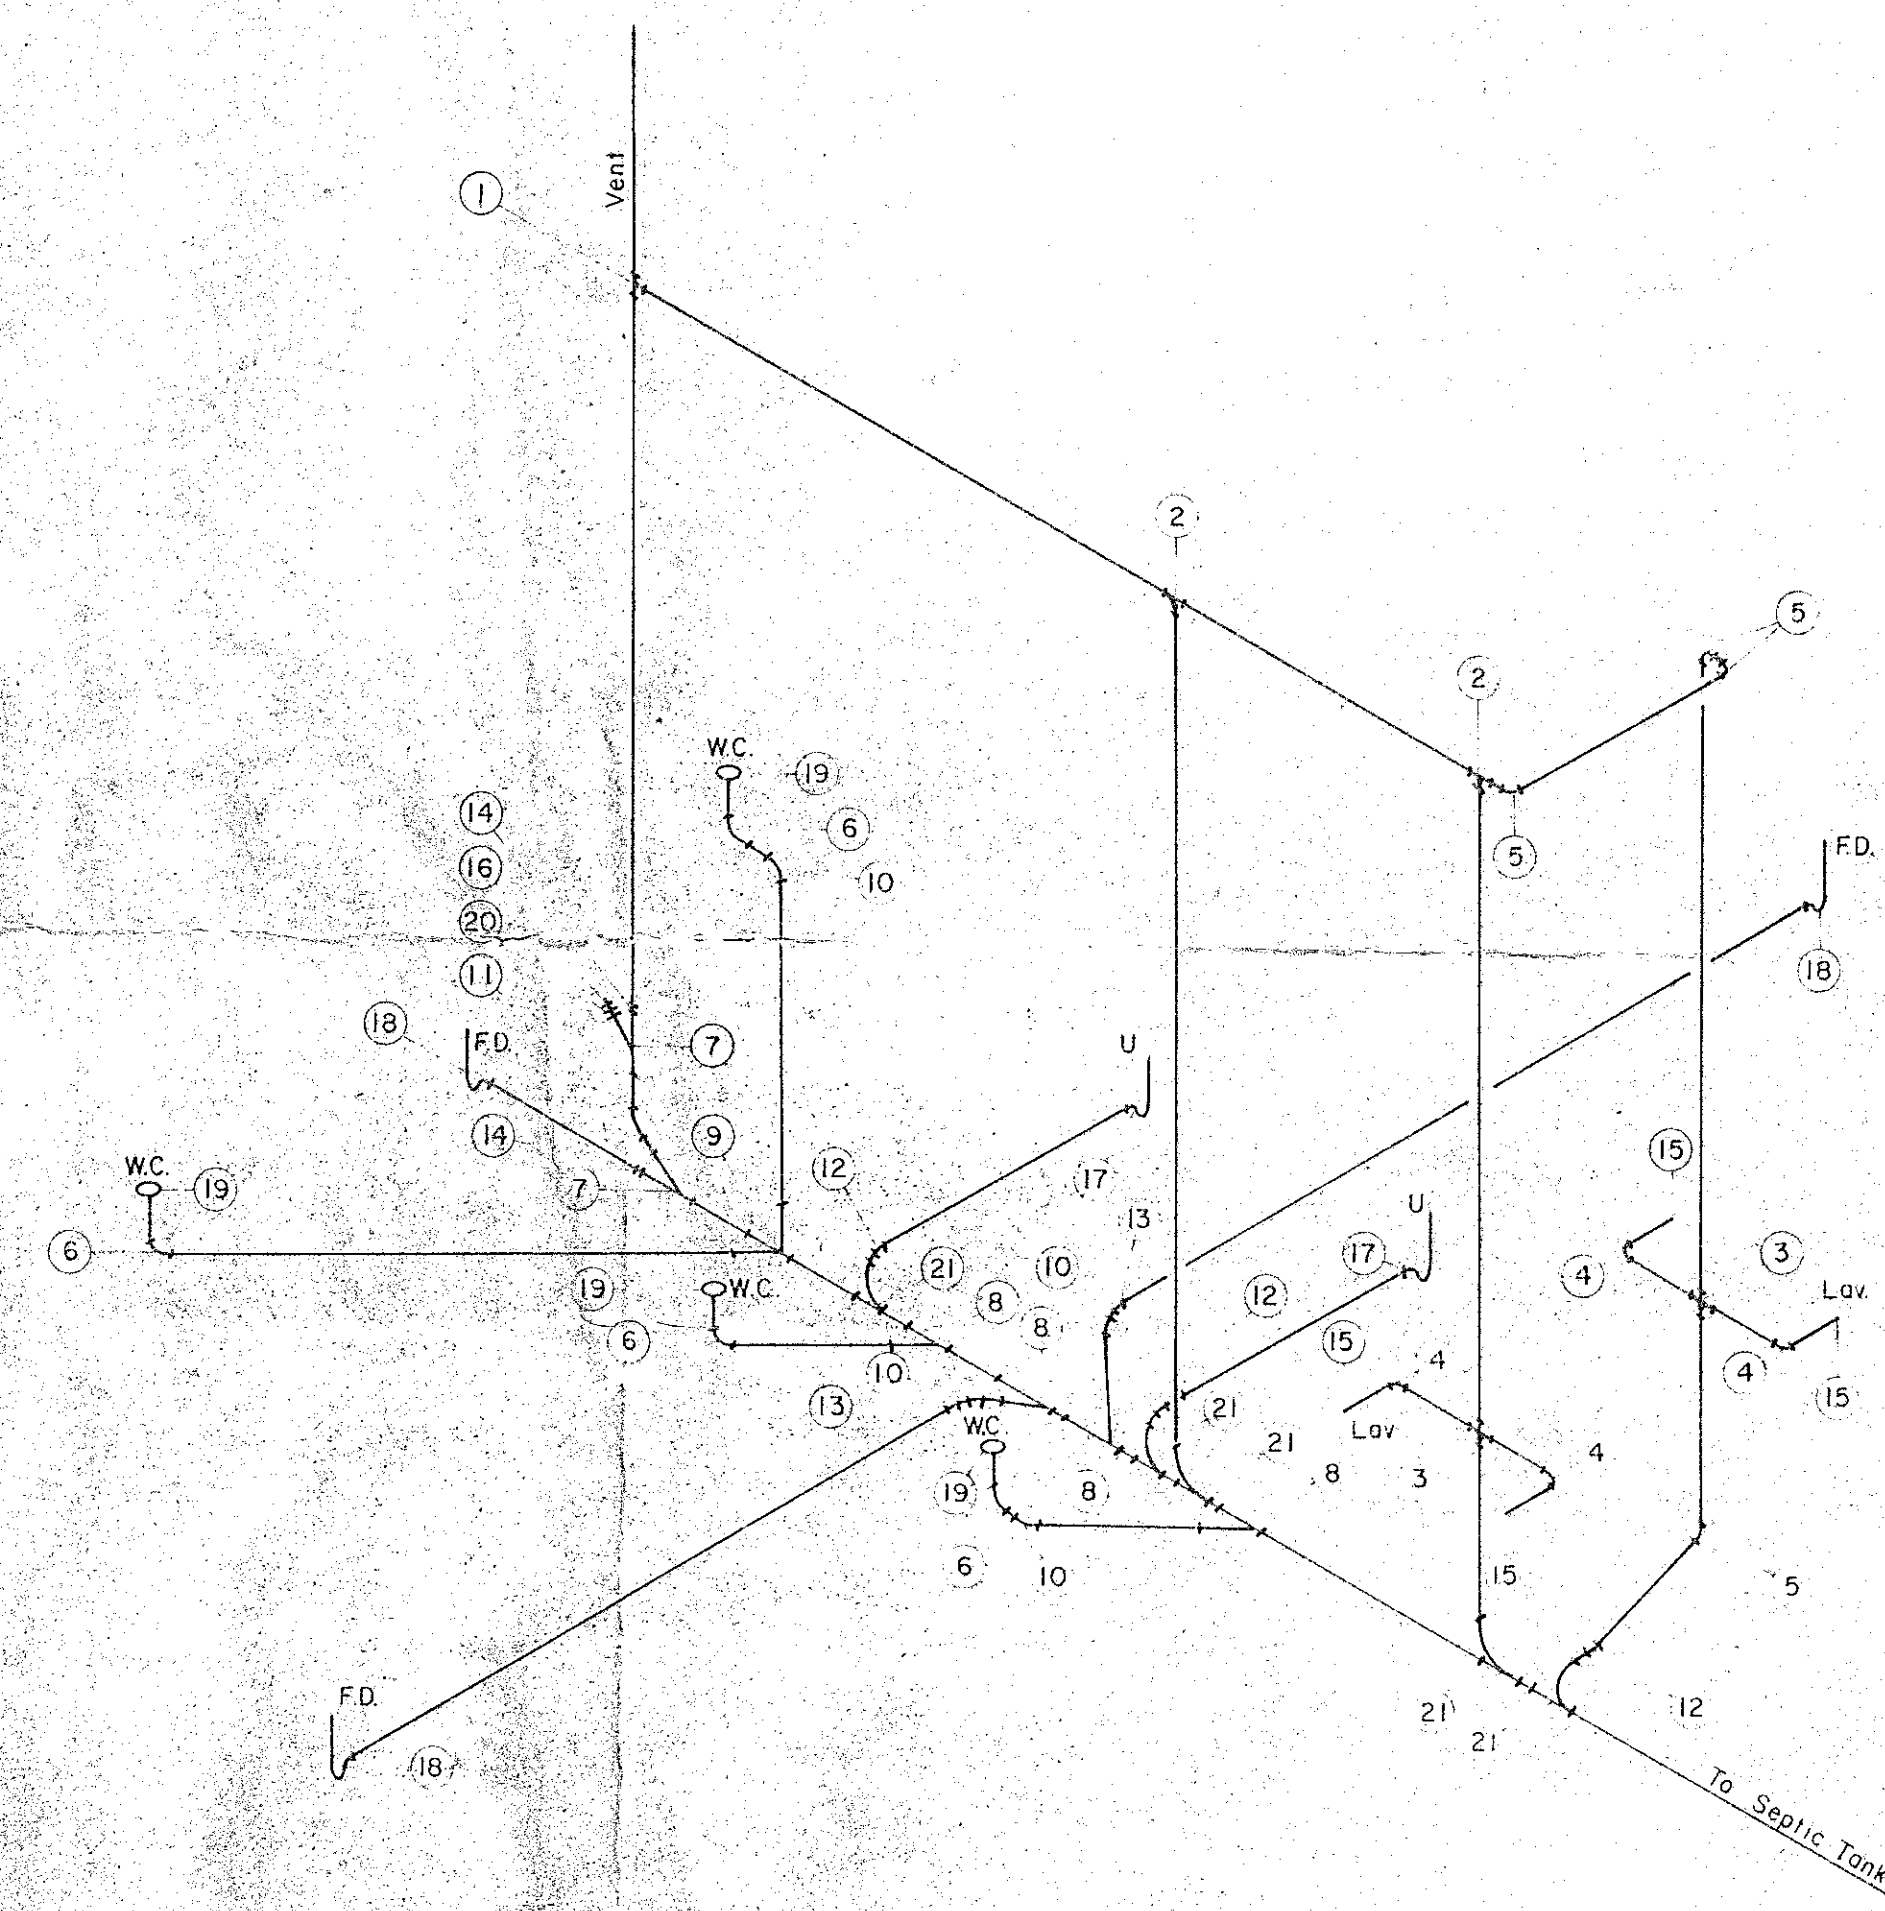

DRAIN, WASTE & VENT SYSTEM ISOMETRIC



THE PROVINCE OF BRITISH COLUMBIA
MINISTRY OF RECREATION AND CONSERVATION
PARKS BRANCH

					APPROVED			POSITION			DATE			NATIONAL TOPOGRAPHIC SHEET 93 6/2			TEN MILE LAKE PROVINCIAL PARK											
														FILE NUMBER 2-1-1-5			6 UNIT TOILET BUILDING PLUMBING DETAILS (BLDGS. A,B & D)											
														MICROFILM NUMBER														
														8 SHEET OF 12			 SCALE AS SHOWN.											
No. REVISION					DRAWN			DATE			CHECKED			DRAWN DATE			CHECKED			SURVEY DATE			DESIGN DG Hunt DATE			DWG. No. 1-1-5 SP11-8		