


LEGEND :

- COUNTOURS (m) ——— 726 ———
TEST PITS - 1990 ● TP 5
SURVEY TRAVERSE HUB △ 'F'
TEMPORARY BENCH MARK △ TBM 2

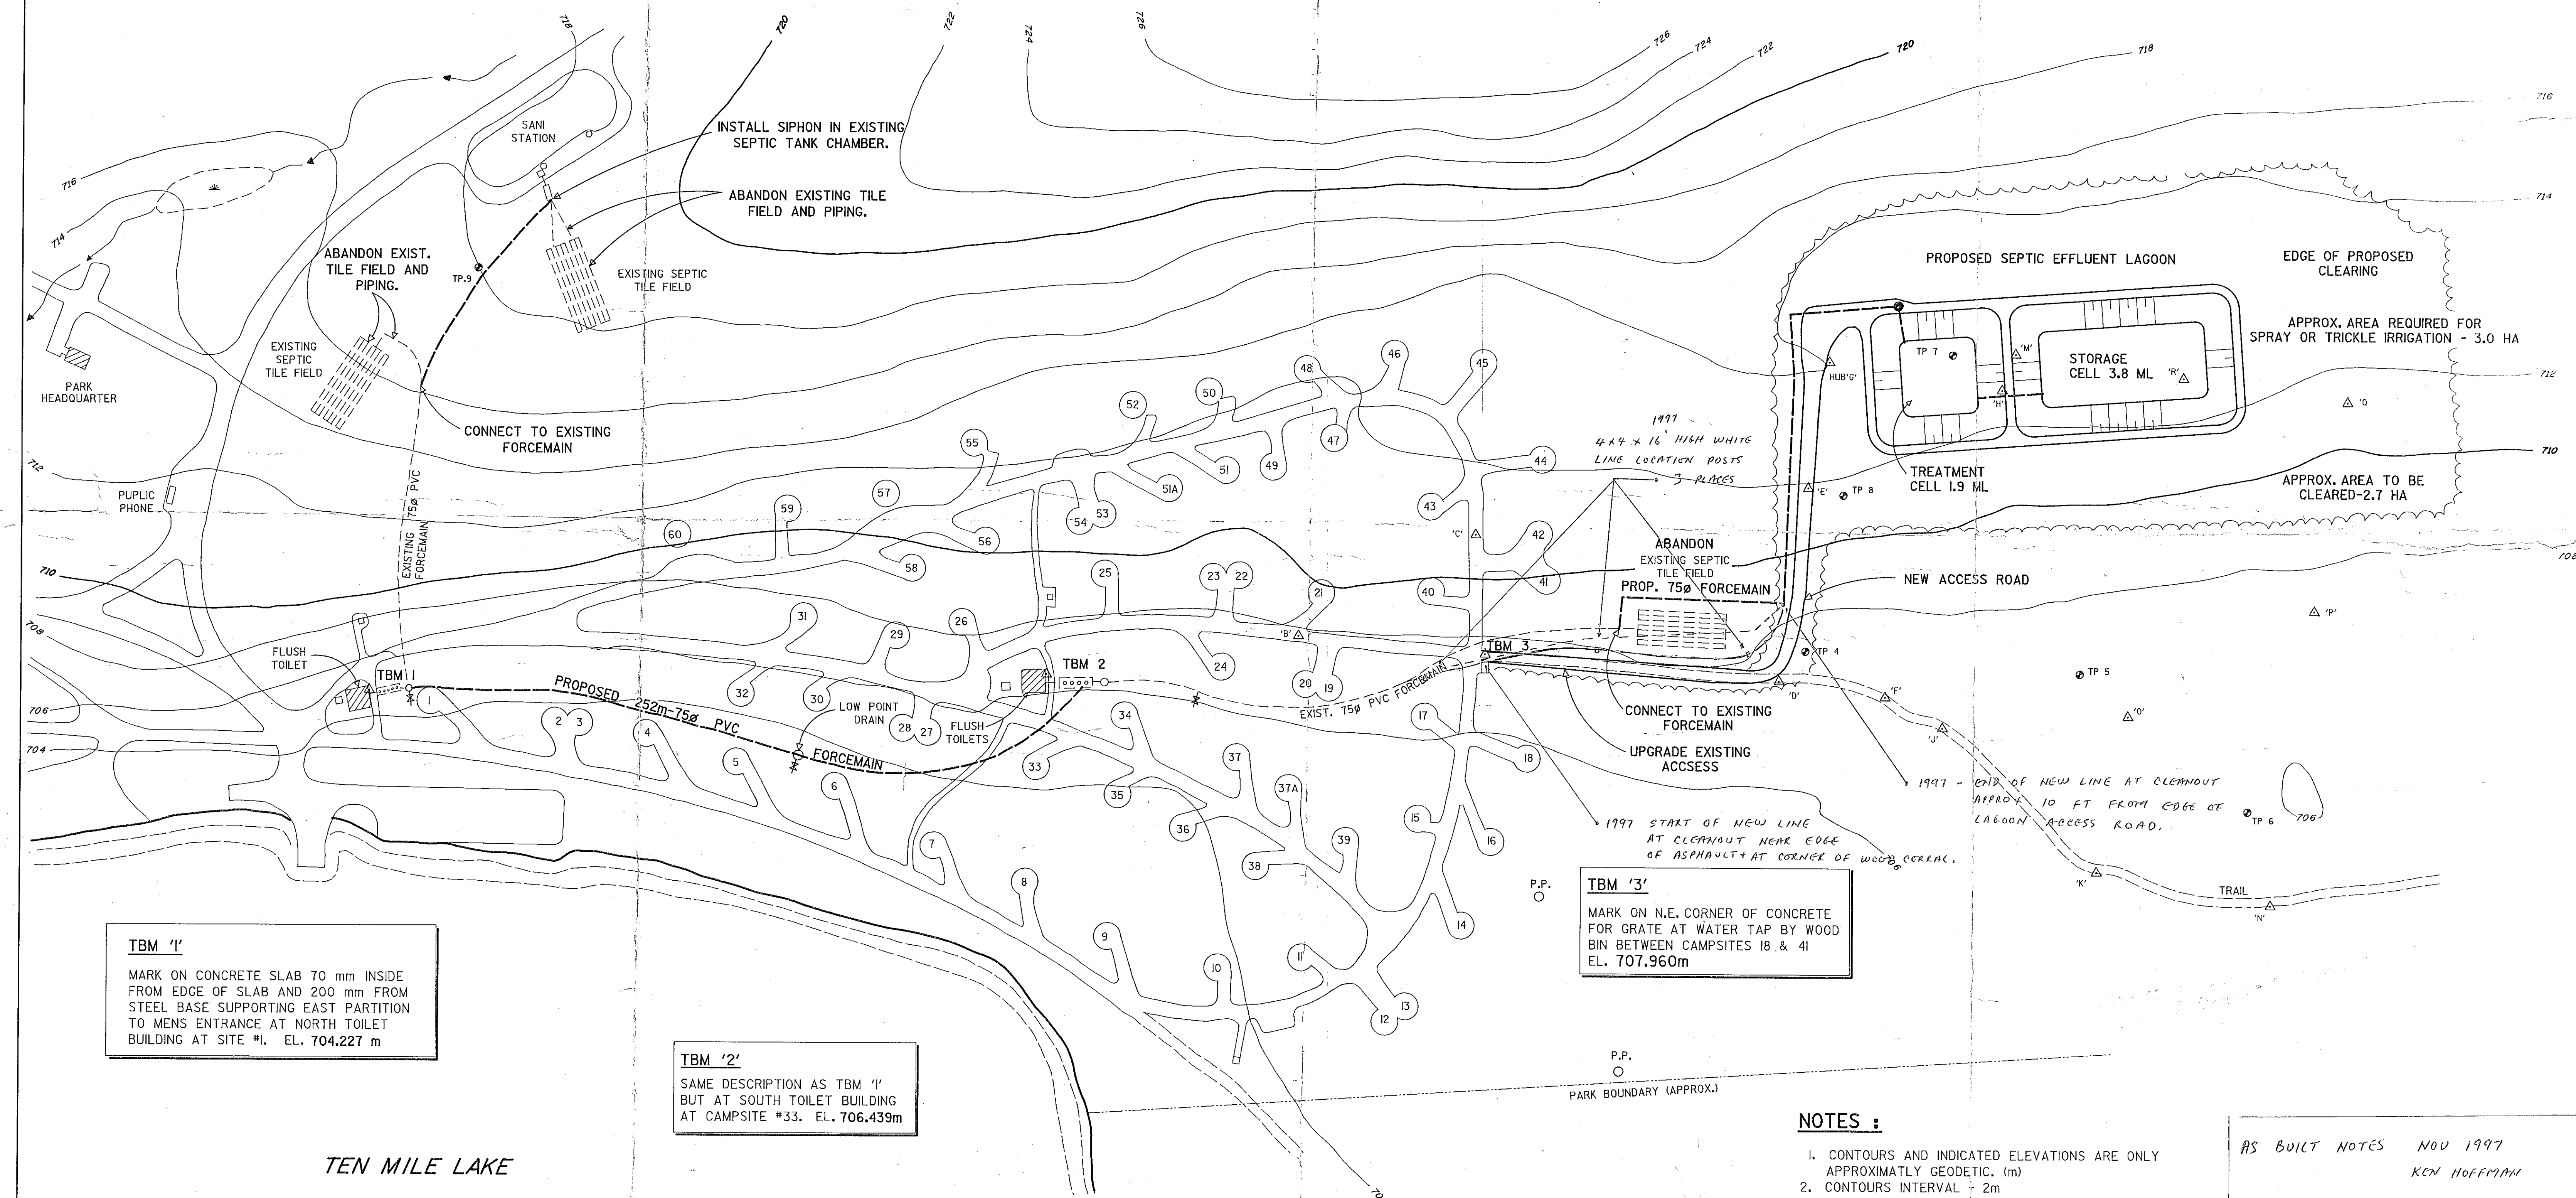

NOTES :

1. CONTOURS AND INDICATED ELEVATIONS ARE ONLY APPROXIMATELY GEODETIC. (m)
2. CONTOURS INTERVAL - 2m

NOV. 1997 NOTES

- PROBLEM - EACH SPRING PFD EXPERIENCED ICE PLUG IN LINE APPROXIMATELY OVER ABANDONED SEPTIC TILE FIELD
- SOLUTION - REPLACE APPROX 350 FT SECTION WITH TWO CLEAN-OUTS AND NO ELBOWS
- LEGEND - DOTTED LINE - AS BUILT 1995 WITH 22 1/2° ELBOWS AND NO CLEANOUTS
- SOLID LINE - NOV 1997 REPLACEMENT LINE ROUTING WITH TWO CLEANOUTS AND NO ELBOWS. CONSTANT GRADE MAINTAINED.

AS BUILT NOTES NOV 1997
KEN HOFFMAN

MINISTRY OF PARKS

SCALE : 1:1000
DATE : JUNE 1995
REVISED :
DRAWN BY : YVONNE H.
REVISED :

TEN MILE LAKE PROVINCIAL PARK
SEWAGE DISPOSAL SYSTEM

SITE PLAN

Carlboo Forest Consultants Ltd.
Post Office Box 800
Vancouver, B.C. V6Y 2K2